

FONTANA AUTO CENTER

On Existing D/F Illuminated Pylon Sign:

- (1) Repaint all Aluminum Surfaces
- (2) Replace All Logo Panels w/ New Routed Thru Panels
- (3) Retrofit Existing Flex Face Cabinet w/ New Face Frame, Retainers, and Blank Logo Panels

16444 S. Highland Ave, Fontana, CA 92336

Table of Contents:

Sheet CV.....	Cover Page
Sheet SP 1.....	Site Plan, Vicinity Map
Sheet DSN 1.0.....	Pylon - Paint Schedule
Sheet DSN 2.0.....	Car Logo Panels - Specifications
Sheet DSN 2.1.....	Logo Panels - Night View
Sheet DSN 3.0.....	Lower Cabinet Retrofit

GENERAL NOTES:
 All work shall comply with
 2022 California Building Code
 2022 California Electrical Code
 2022 California Energy Code, Title 24
 2022 California Existing Building Code
 2022 California Fire Code
 2022 California Green Building Standards Code
 2022 California Mechanical Code
 2022 California Referenced Standards Code

 These signs are intended to be installed in accordance with the requirements of Article 600 of the National Electrical Code and/or other applicable local codes. This includes proper grounding and bonding of signs.

GENERAL NOTES
 NOTE: CUSTOMER TO PROVIDE TITLE 24 COMPLIANT SIGN LIGHTING CONTROLS (AUTOMATIC TIME SWITCH & PHOTO CELL)
 CUSTOMER TO PROVIDE PRIMARY POWER TO EACH SIGN LOCATION
DEDICATED SIGN CIRCUIT

California Region
 CALIFORNIA CONTRACTOR LICENSE NO. 980688
LOS ANGELES
 10235 Belgrave Avenue
 Jurupa Valley, CA 91752
 (866) 959-3726



© YESCO LLC. This drawing was created to assist in visualizing our proposal. The original ideas herein are the property of YESCO LLC. Permission to copy or revise this drawing can only be obtained through a written agreement with YESCO LLC. See your sales representative or call the nearest office of YESCO LLC.

PROJECT NAME / LOCATION:
**FONTANA
 AUTO CENTER**
 Fontana Auto Center
 16444 S. Highland Ave
 Fontana, CA 92336

DESIGN NUMBER:
ART R2 OPY-58333
LEVEL 3

ACCOUNT EXECUTIVE:
DAVE JONES
 DESIGNER: DATE:
L TAYLOR 08/16/23

REVISIONS:

DESIGNER:	DATE:
△ LT	08/29/23
Increase number of logo panels to 8	
△ KA	10/03/23
Revised lower cabinet to new blank logo panels, changed no. of panels back to 6	



Note: The colors depicted on this rendering may not match actual colors used on the finished display. Please refer to the detail drawing for the approved color specifications.
 Note: The cost of providing electrical wiring to the sign area, all required permits and all special inspections are not included in this sign proposal.
 Note: The proportion of signs shown on building and landscape area photos is an approximate representation.
 Note: This sign is intended to be installed in accordance with the requirements of Article 600 of the National Electrical Code and/or other applicable local codes. This includes proper grounding and bonding of the sign.


SHEET:
CV

SIGN KEY / SIGN LEGEND




A PYLON - Current Condition

SITE PLAN

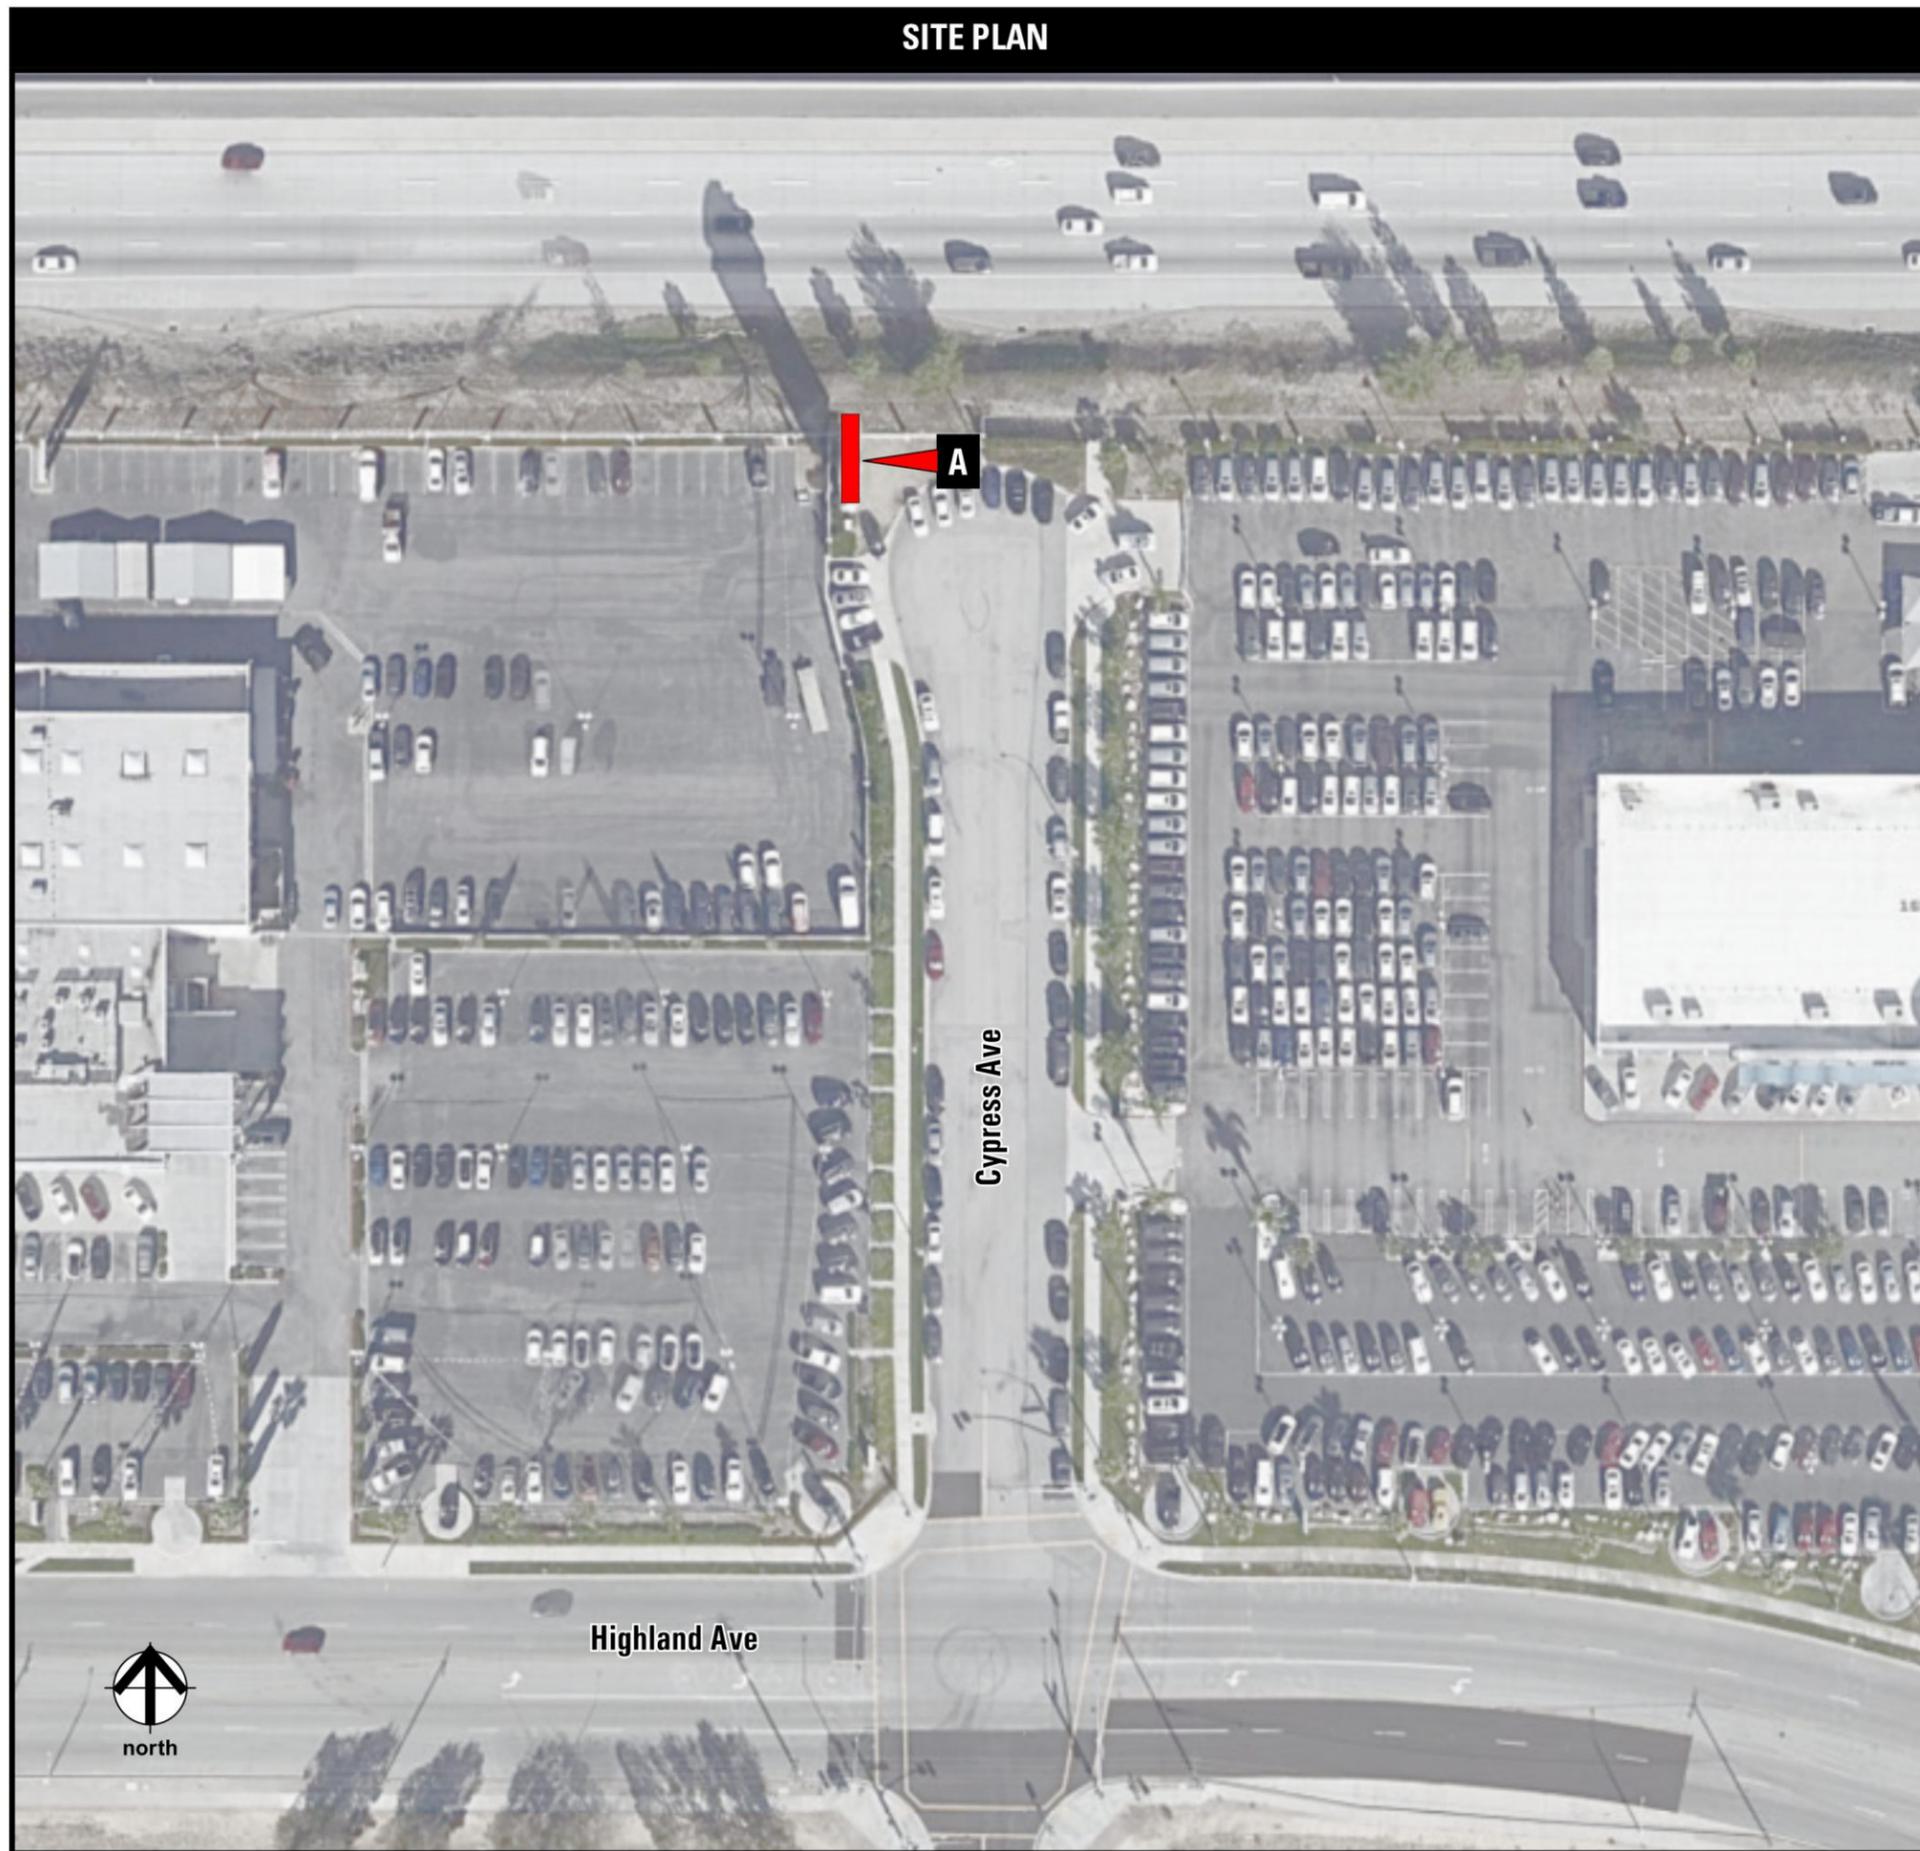

VICINITY MAP

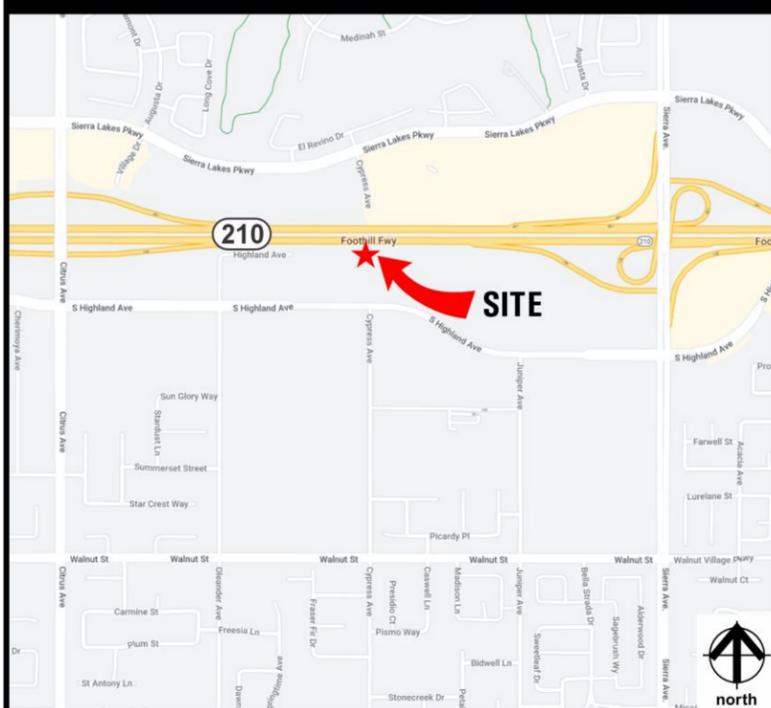

California Region
 CALIFORNIA CONTRACTOR LICENSE NO. 980698
LOS ANGELES
 10235 Bellegrave Avenue
 Jurupa Valley, CA 91752
 (866) 959-3726



© YESCO LLC. This drawing was created to assist in visualizing our proposal. The original ideas herein are the property of YESCO LLC. Permission to copy or revise this drawing can only be obtained through a written agreement with YESCO LLC. See your sales representative or call the nearest office of YESCO LLC.

PROJECT NAME / LOCATION:
FONTANA
AUTO CENTER
 Fontana Auto Center
 16444 S. Highland Ave
 Fontana, CA 92336


DESIGN NUMBER:
ART R2 OPY-58333
LEVEL 3
 ACCOUNT EXECUTIVE:
DAVE JONES
 DESIGNER: DATE:
L TAYLOR 08/16/23

REVISIONS:
 DESIGNER: DATE:
 △ LT 08/29/23
 Increase number of logo panels to 8
 △ KA 10/03/23
 Revised lower cabinet to new blank logo panels, changed no. of panels back to 6

Lane Taylor

Note: The colors depicted on this rendering may not match actual colors used on the finished display. Please refer to the detail drawing for the approved color specifications.
 Note: The cost of providing electrical wiring to the sign area, all required permits and all special inspections are not included in this sign proposal.
 Note: The proportion of signs shown on building and landscape area photos is an approximate representation.
 Note: This sign is intended to be installed in accordance with the requirements of Article 600 of the National Electrical Code and/or other applicable local codes. This includes proper grounding and bonding of the sign.

SHEET:
SP1

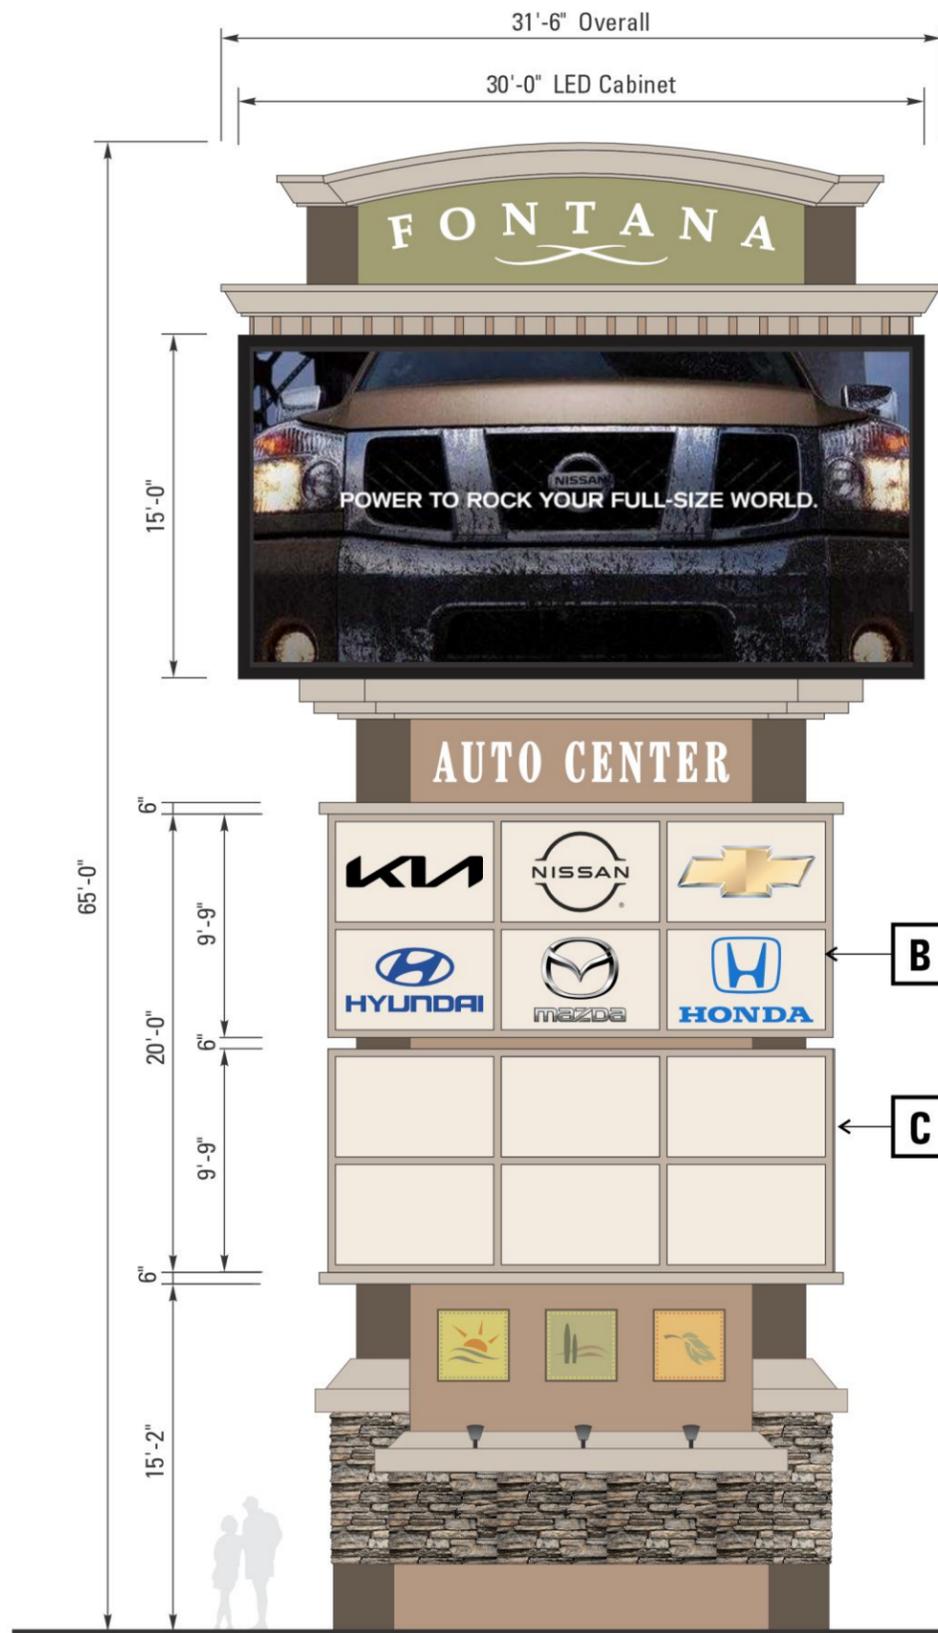

A Repaint Existing Pylon with Specified Colors

B New Illuminated Tenant Logos on Existing D/F Pylon

C Retrofit Existing D/f Illuminated "City of Fontana" Flex Face Cabinet w/ New Aluminum Face Frame, Retainers, And Blank Tenant Panels

Color Key

- P-1** Matthews 26A-1A "Café Noir"
- P-2** Matthews 34C-3D "Grenadier Gold"
- P-3** Matthews 34A-3P "Manhattan Beige"
- P-4** Matthews 39A-2P "Winter Sky"
- P-5** Matthews 49A-1A "Shadey Olive"



EXISTING



NEW

Scale: 1/8" = 1'-0"

California Region
 CALIFORNIA CONTRACTOR LICENSE NO. 980698
 LOS ANGELES
 10235 Bellegrave Avenue
 Jurupa Valley, CA 91752
 (866) 959-3726



© YESCO LLC This drawing was created to assist in visualizing our proposal. The original ideas herein are the property of YESCO LLC. Permission to copy or revise this drawing can only be obtained through a written agreement with YESCO LLC. See your sales representative or call the nearest office of YESCO LLC.

PROJECT NAME / LOCATION:

**FONTANA
 AUTO CENTER**

Fontana Auto Center
 16444 S. Highland Ave
 Fontana, CA 92336

DESIGN NUMBER:
ART R2 OPY-58333

LEVEL 3

ACCOUNT EXECUTIVE:
DAVE JONES
 DESIGNER: DATE:
L TAYLOR 08/16/23

REVISIONS:

DESIGNER:	DATE:
△ LT	08/29/23
Increase number of logo panels to 8	
△ KA	10/03/23
Revised lower cabinet to new blank logo panels, changed no. of panels back to 6	

Lane Taylor

Note: The colors depicted on this rendering may not match actual colors used on the finished display. Please refer to the detail drawing for the approved color specifications.
 Note: The cost of providing electrical wiring to the sign area, all required permits and all special inspections are not included in this sign proposal.
 Note: The proportion of signs shown on building and landscape area photos is an approximate representation.
 Note: This sign is intended to be installed in accordance with the requirements of Article 600 of the National Electrical Code and/or other applicable local codes. This includes proper grounding and bonding of the sign.

SHEET:

DSN 1.0

UL This sign is intended to be installed in accordance with the requirements of Article 600 of the National Electrical Code and/or other applicable local codes. This includes proper grounding and bonding of the sign.


GENERAL NOTES
 NOTE: CUSTOMER TO PROVIDE TITLE 24 COMPLIANT SIGN LIGHTING CONTROLS (AUTOMATIC TIME SWITCH & PHOTO CELL)
 CUSTOMER TO PROVIDE PRIMARY POWER TO EACH SIGN LOCATION
DEDICATED SIGN CIRCUIT

SIGN SPECS			
A	PANELS	TYPE	1/8" Alum w/ Routed Thru Graphics
		FACES	Clear acrylic w/ 2nd surface diffuser
		1st SURF VINYL	See Color Key

COLOR KEY		
	VINYL	3M 3630-127 Intense Blue (Honda)
	VINYL	3M 3630-157 Sultan Blue (Hyundai)
	VINYL	3M 3635-222 Dual Color Black (Kia & Nissan)
	VINYL	Digital Print (Chevy & Mazda)
	PAINT	Matthews 39A-2P "Winter Sky"

NOTE: UNLESS OTHERWISE NOTED, THE COLORS DEPICTED ON THIS RENDERING MAY NOT MATCH ACTUAL COLORS ON FINISHED DISPLAY. PLEASE REFER TO COLOR-CALLOUTS AND THEIR APPROPRIATE VENDOR SPECIFIED SAMPLES FOR APPROVED COLOR SPECIFICATIONS

****NOTE****
 ALL DIMENSIONS TO BE FIELD VERIFIED PRIOR TO MANUFACTURING

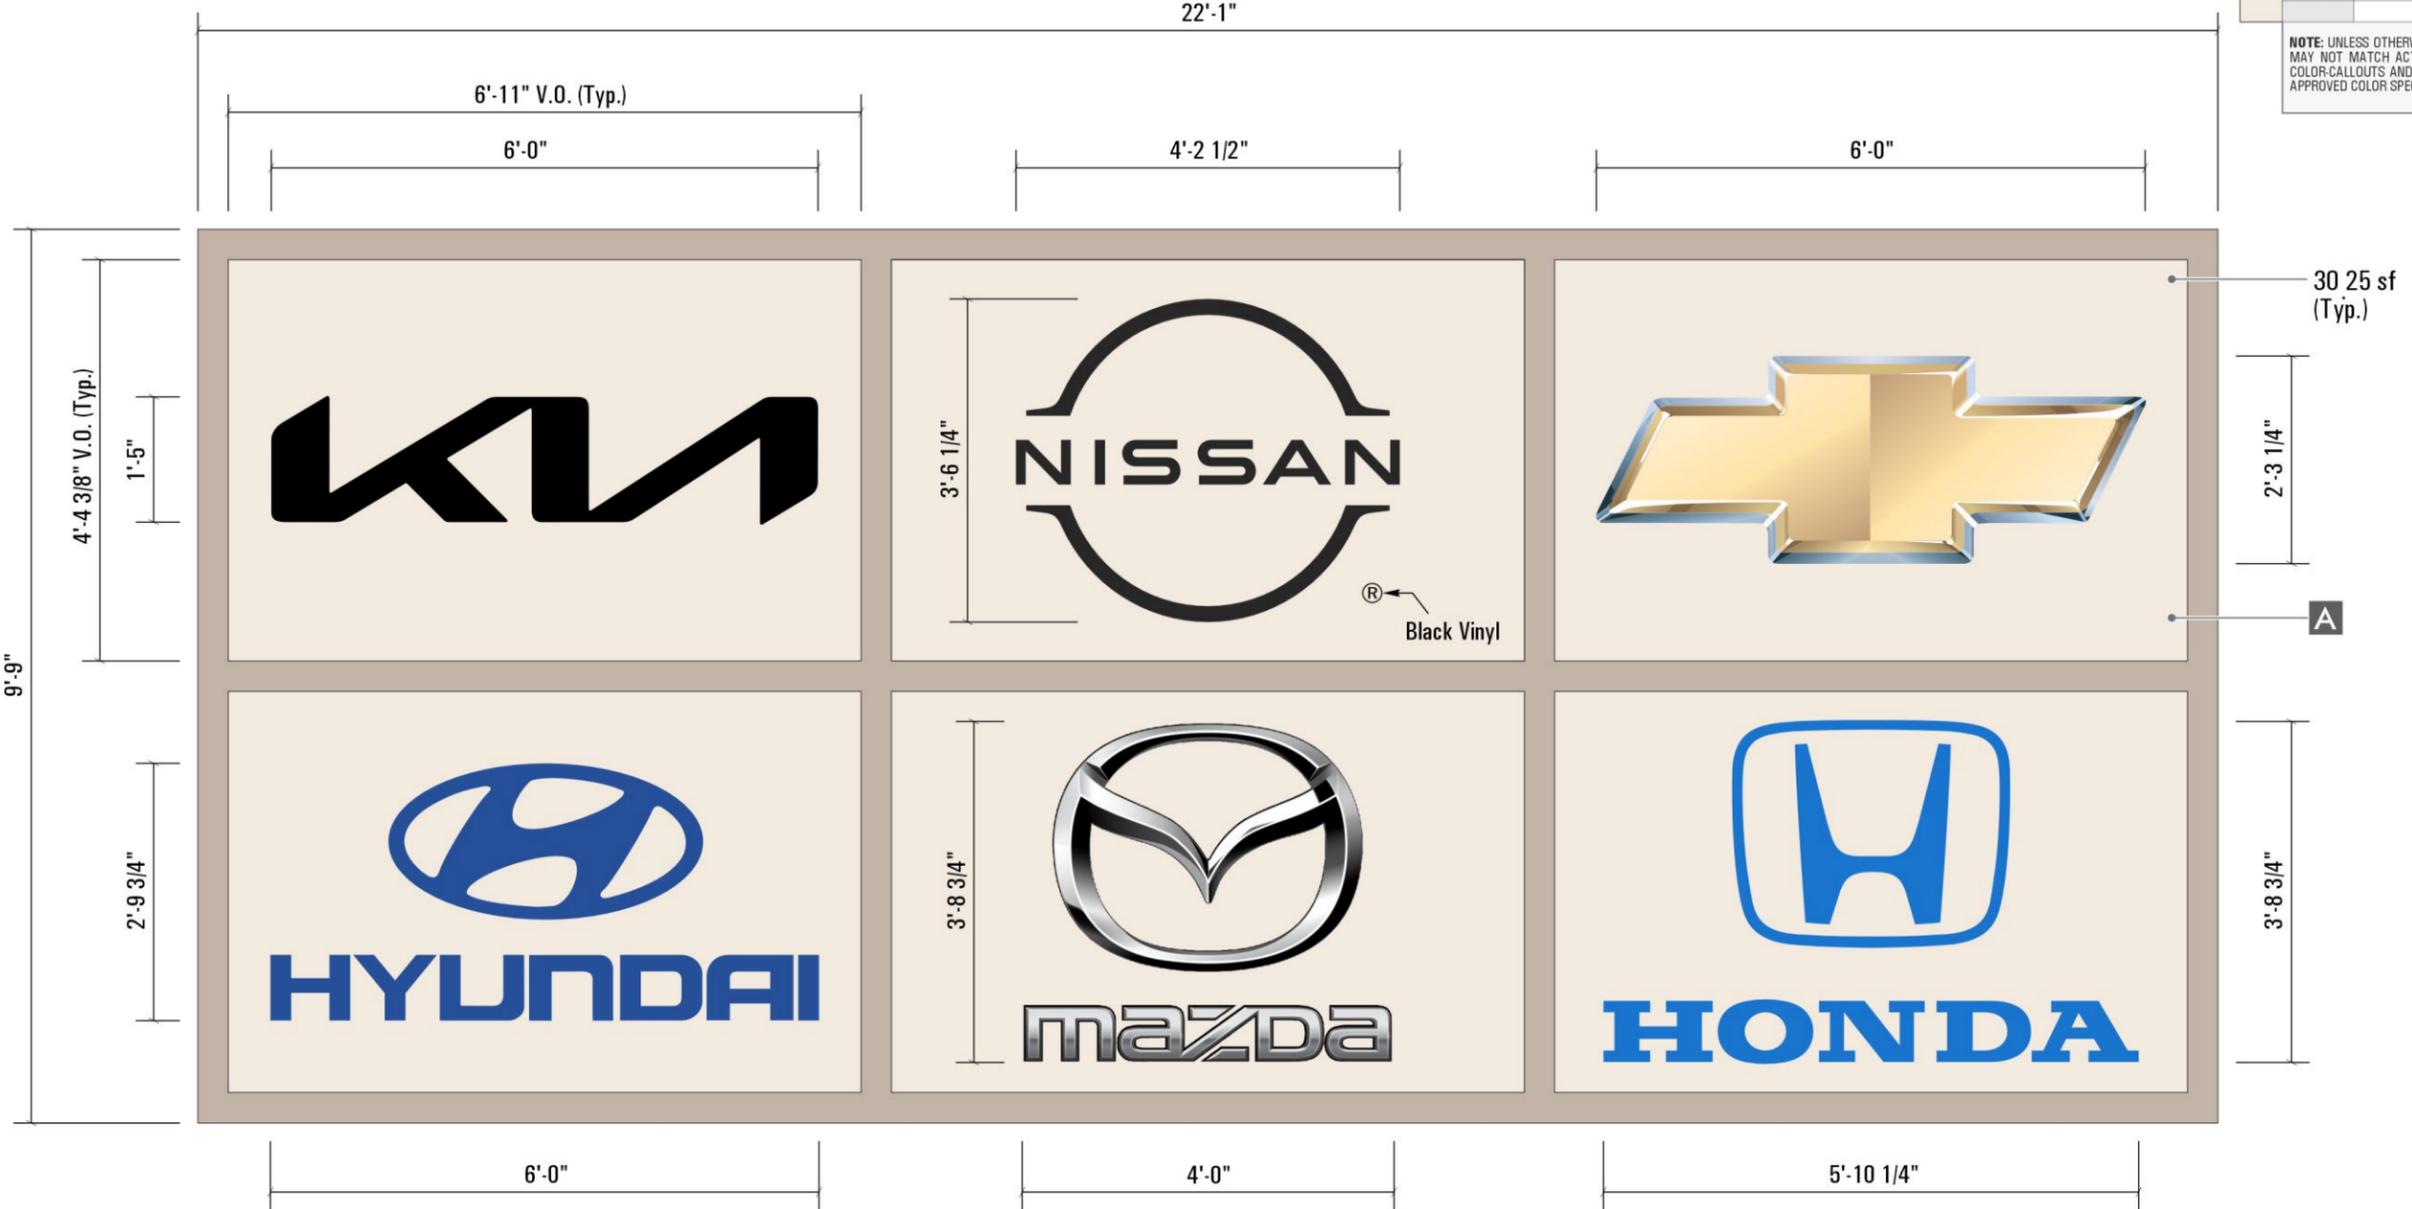

30 25 sf (Typ.)

A

B **New Illuminated Tenant Logos on Existing D/F Pylon**
 QUANTITY: Twelve (12) Logos (2 of ea.), Provide and Install

Scale: 1/2" = 1'-0"

California Region
 CALIFORNIA CONTRACTOR LICENSE NO. 980698
LOS ANGELES
 10235 Belgrave Avenue
 Juruca Valley, CA 91752
 (866) 959-3726

YESCO®

© YESCO LLC This drawing was created to assist in visualizing our proposal. The original ideas herein are the property of YESCO LLC. Permission to copy or revise this drawing can only be obtained through a written agreement with YESCO LLC. See your sales representative or call the nearest office of YESCO LLC.

PROJECT NAME / LOCATION:
FONTANA AUTO CENTER
 Fontana Auto Center
 16444 S. Highland Ave
 Fontana, CA 92336

DESIGN NUMBER:
ART R2 OPY-58333
LEVEL 3

ACCOUNT EXECUTIVE:
DAVE JONES
 DESIGNER: DATE:
L TAYLOR 08/16/23


REVISIONS:

DESIGNER:	DATE:
△ LT	08/29/23
Increase number of logo panels to 8	
△ KA	10/03/23
Revised lower cabinet to new blank logo panels, changed no. of panels back to 6	

Lana Taylor

Note: The colors depicted on this rendering may not match actual colors used on the finished display. Please refer to the detail drawing for the approved color specifications.
 Note: The cost of providing electrical wiring to the sign area, all required permits and all special inspections are not included in this sign proposal.
 Note: The proportion of signs shown on building and landscape area photos is an approximate representation.
 Note: This sign is intended to be installed in accordance with the requirements of Article 600 of the National Electrical Code and/or other applicable local codes. This includes proper grounding and bonding of the sign.

SHEET:
DSN 2.0

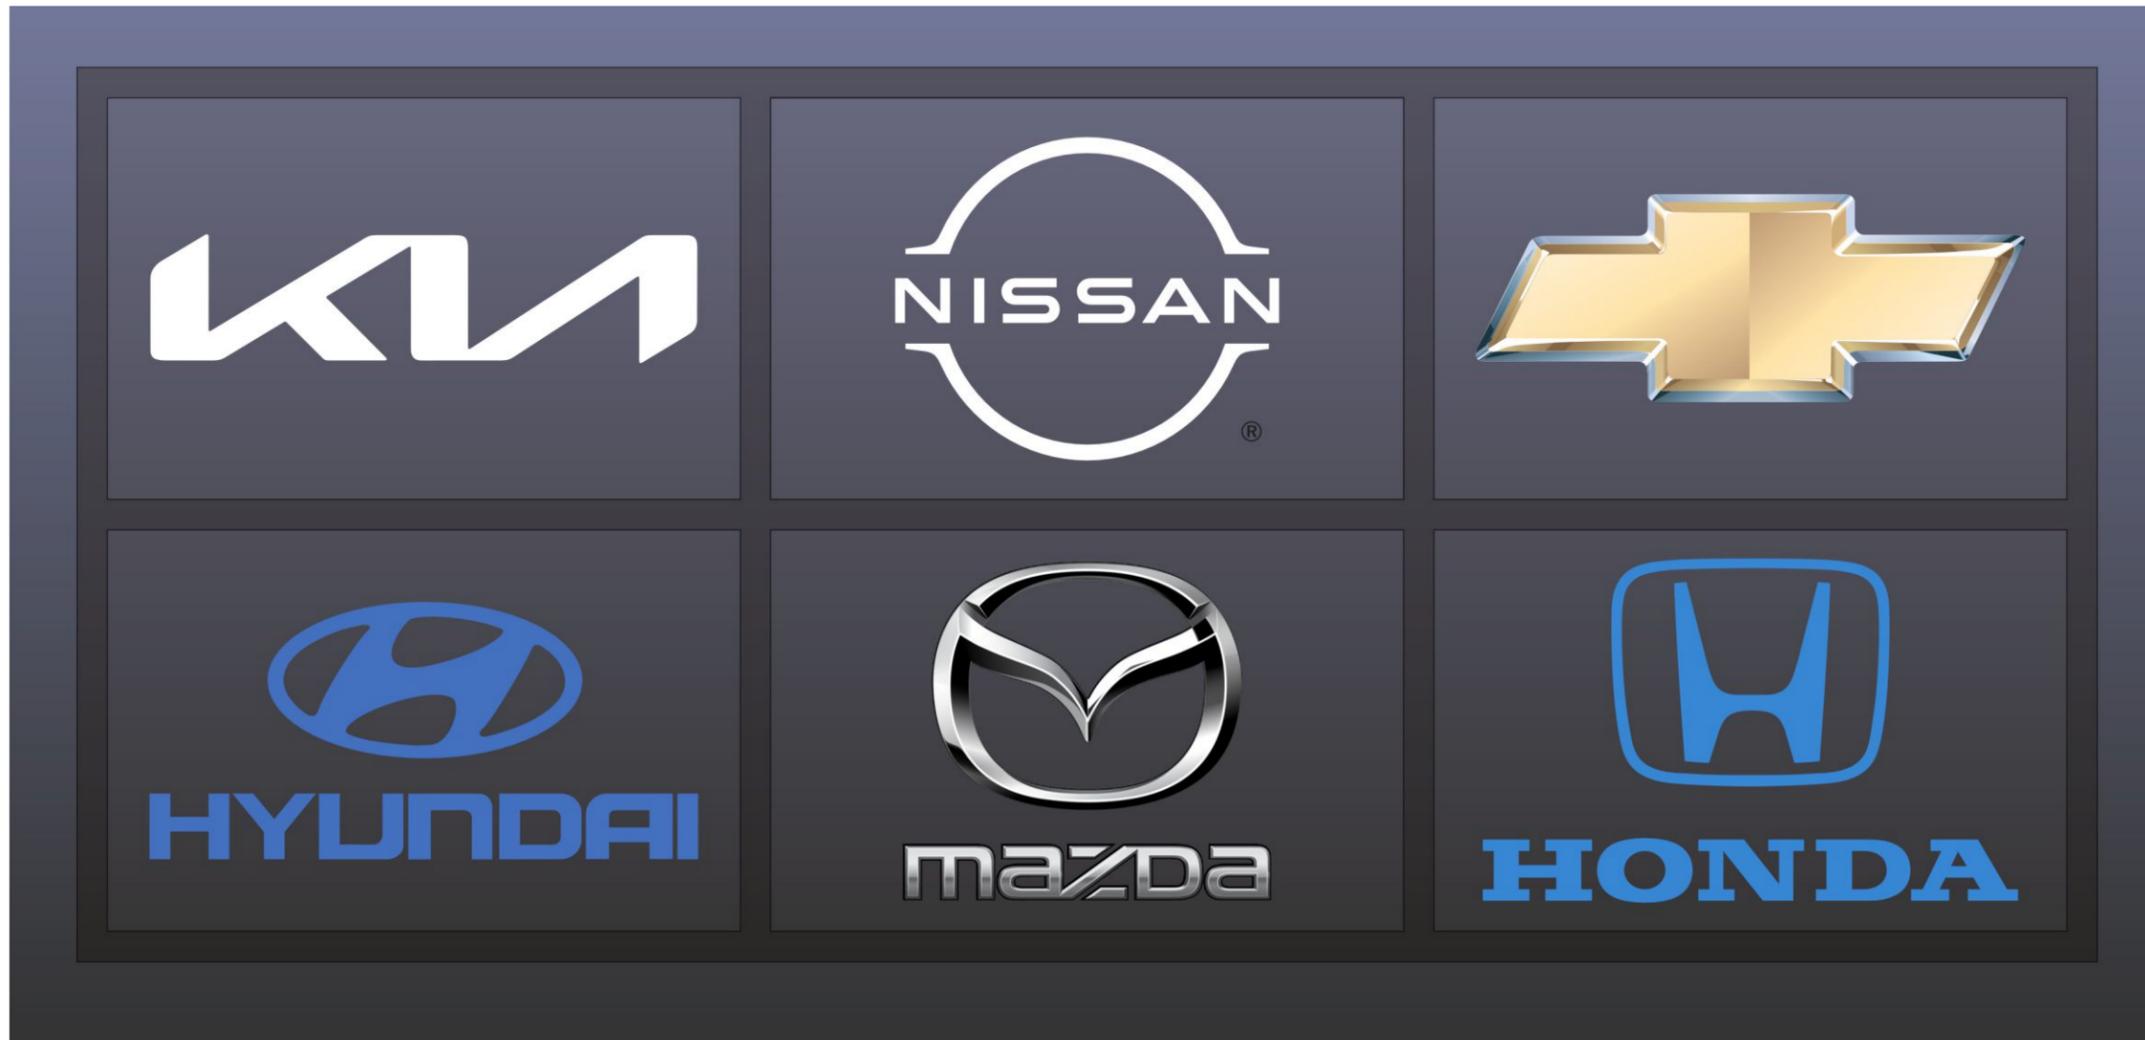

B Simulated Night View

Scale: 1/2" = 1'-0"

California Region

CALIFORNIA CONTRACTOR LICENSE NO. 980698

LOS ANGELES
10235 Bellegrove Avenue
Jurupa Valley, CA 91752
(866) 959-3726



© YESCO LLC. This drawing was created to assist in visualizing our proposal. The original ideas herein are the property of YESCO LLC. Permission to copy or revise this drawing can only be obtained through a written agreement with YESCO LLC. See your sales representative or call the nearest office of YESCO LLC.

PROJECT NAME / LOCATION:

**FONTANA
AUTO CENTER**

Fontana Auto Center
16444 S. Highland Ave
Fontana, CA 92336

DESIGN NUMBER:
ART R2 OPY-58333

LEVEL 3

ACCOUNT EXECUTIVE:

DAVE JONES

DESIGNER: DATE:

L TAYLOR 08/16/23

REVISIONS:

DESIGNER: DATE:

△ **LT 08/29/23**

Increase number of logo panels to 8

△ **KA 10/03/23**

Revised lower cabinet to new blank logo panels, changed no. of panels back to 6

Note: The colors depicted on this rendering may not match actual colors used on the finished display. Please refer to the detail drawing for the approved color specifications.

Note: The cost of providing electrical wiring to the sign area, all required permits and all special inspections are not included in this sign proposal.

Note: The proportion of signs shown on building and landscape area photos is an approximate representation.

Note: This sign is intended to be installed in accordance with the requirements of Article 600 of the National Electrical Code and/or other applicable local codes. This includes proper grounding and bonding of the sign.

SHEET:

DSN 2.1

UL This sign is intended to be installed in accordance with the requirements of Article 600 of the National Electrical Code and/or other applicable local codes. This includes proper grounding and bonding of the sign.

GENERAL NOTES
 NOTE: CUSTOMER TO PROVIDE TITLE 24 COMPLIANT SIGN LIGHTING CONTROLS (AUTOMATIC TIME SWITCH & PHOTO CELL)
 CUSTOMER TO PROVIDE PRIMARY POWER TO EACH SIGN LOCATION
DEDICATED SIGN CIRCUIT

SIGN SPECS


A	CABINET	RETROFIT	RETROFIT EXISTING FLEX FACE CABINET WITH NEW ALUMINUM FACE FRAME AND RETAINERS PAINTED P-3
	TENANT FACES		ALUMINUM PAINTED P-4

COLOR KEY

P-3	PAINT	Matthews 34A-3P "Manhattan Beige"
P-4	PAINT	Matthews 39A-2P "Winter Sky"

NOTE: UNLESS OTHERWISE NOTED, THE COLORS DEPICTED ON THIS RENDERING MAY NOT MATCH ACTUAL COLORS ON FINISHED DISPLAY. PLEASE REFER TO COLOR-CALLOUTS AND THEIR APPROPRIATE VENDOR SPECIFIED SAMPLES FOR APPROVED COLOR SPECIFICATIONS

****NOTE****
 ALL DIMENSIONS TO BE FIELD VERIFIED PRIOR TO MANUFACTURING

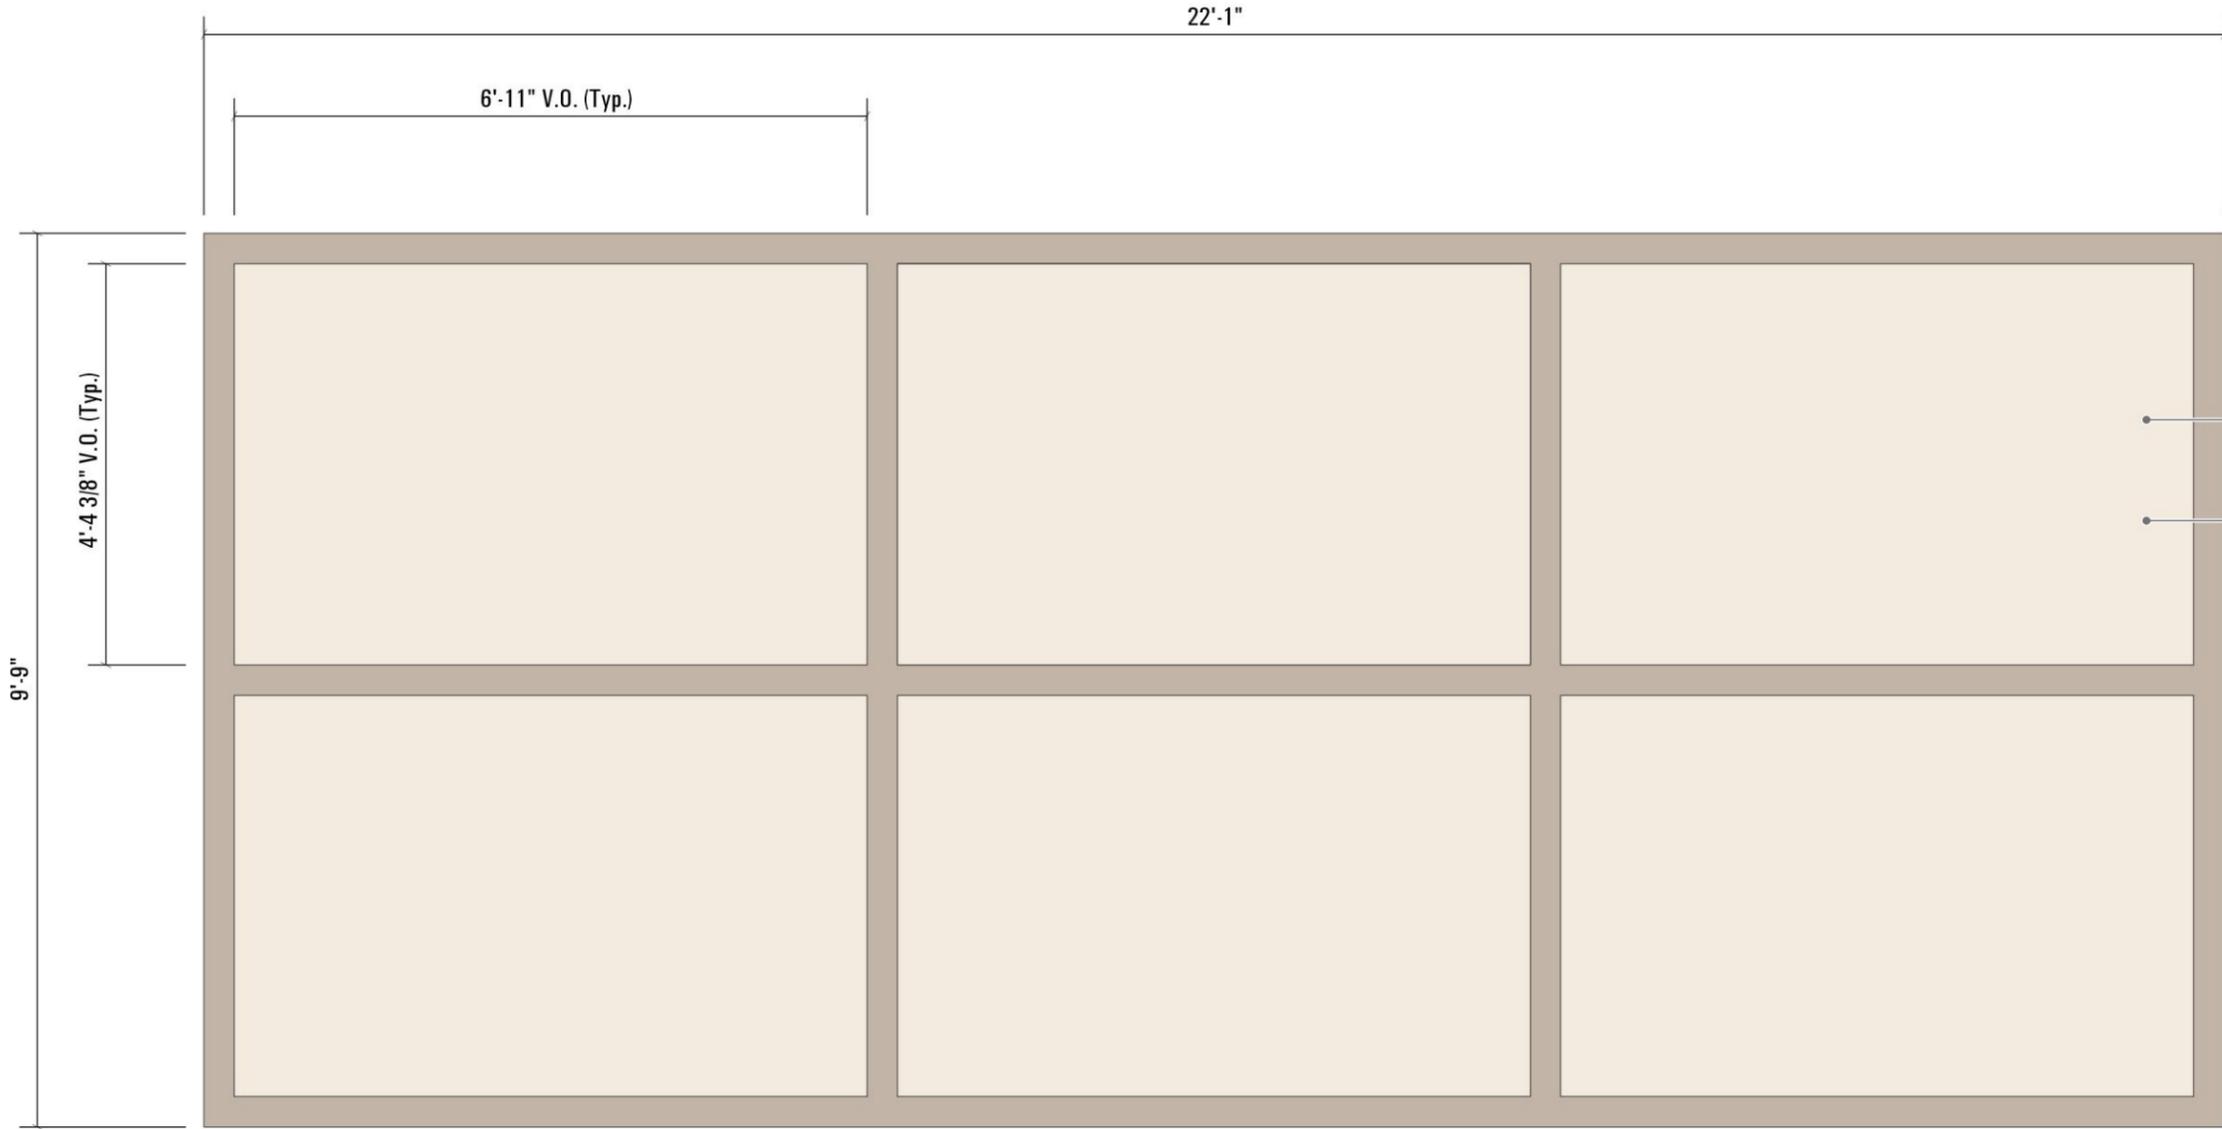

California Region
 CALIFORNIA CONTRACTOR LICENSE NO. 980698
LOS ANGELES
 10235 Bellegrove Avenue
 Juruca Valley, CA 91752
 (866) 959-3726



© YESCO LLC This drawing was created to assist in visualizing our proposal. The original ideas herein are the property of YESCO LLC. Permission to copy or reuse this drawing can only be obtained through a written agreement with YESCO LLC. See your sales representative or call the nearest office of YESCO LLC.

PROJECT NAME / LOCATION:

FONTANA
AUTO CENTER
 Fontana Auto Center
 16444 S. Highland Ave
 Fontana, CA 92336

DESIGN NUMBER:
ART R2 OPY-58333
LEVEL 3

ACCOUNT EXECUTIVE:
DAVE JONES
 DESIGNER: DATE:
L TAYLOR 08/16/23

REVISIONS:
 DESIGNER: DATE:
 △ LT 08/29/23
 Increase number of logo panels to 8
 △ KA 10/03/23
 Revised lower cabinet to new blank logo panels, changed no. of panels back to 6

Note: The colors depicted on this rendering may not match actual colors used on the finished display. Please refer to the detail drawing for the approved color specifications.
 Note: The cost of providing electrical wiring to the sign area, all required permits and all special inspections are not included in this sign proposal.
 Note: The proportion of signs shown on building and landscape area photos is an approximate representation.
 Note: This sign is intended to be installed in accordance with the requirements of Article 600 of the National Electrical Code and/or other applicable local codes. This includes proper grounding and bonding of the sign.

SHEET:

DSN 2.0

C **RETROFIT EXISTING D/F ILLUMINATED "Cit of Fontana" FLEX FACE CABINET with New Aluminum Face Frame, Retainers, and Blank Tenant Panels**
 QUANTITY: Twelve (12) Logos (2 of ea.), Provide and Install
 Scale: 1/2" = 1'-0"